
BROWNLEY COURT SIXTH FLOOR

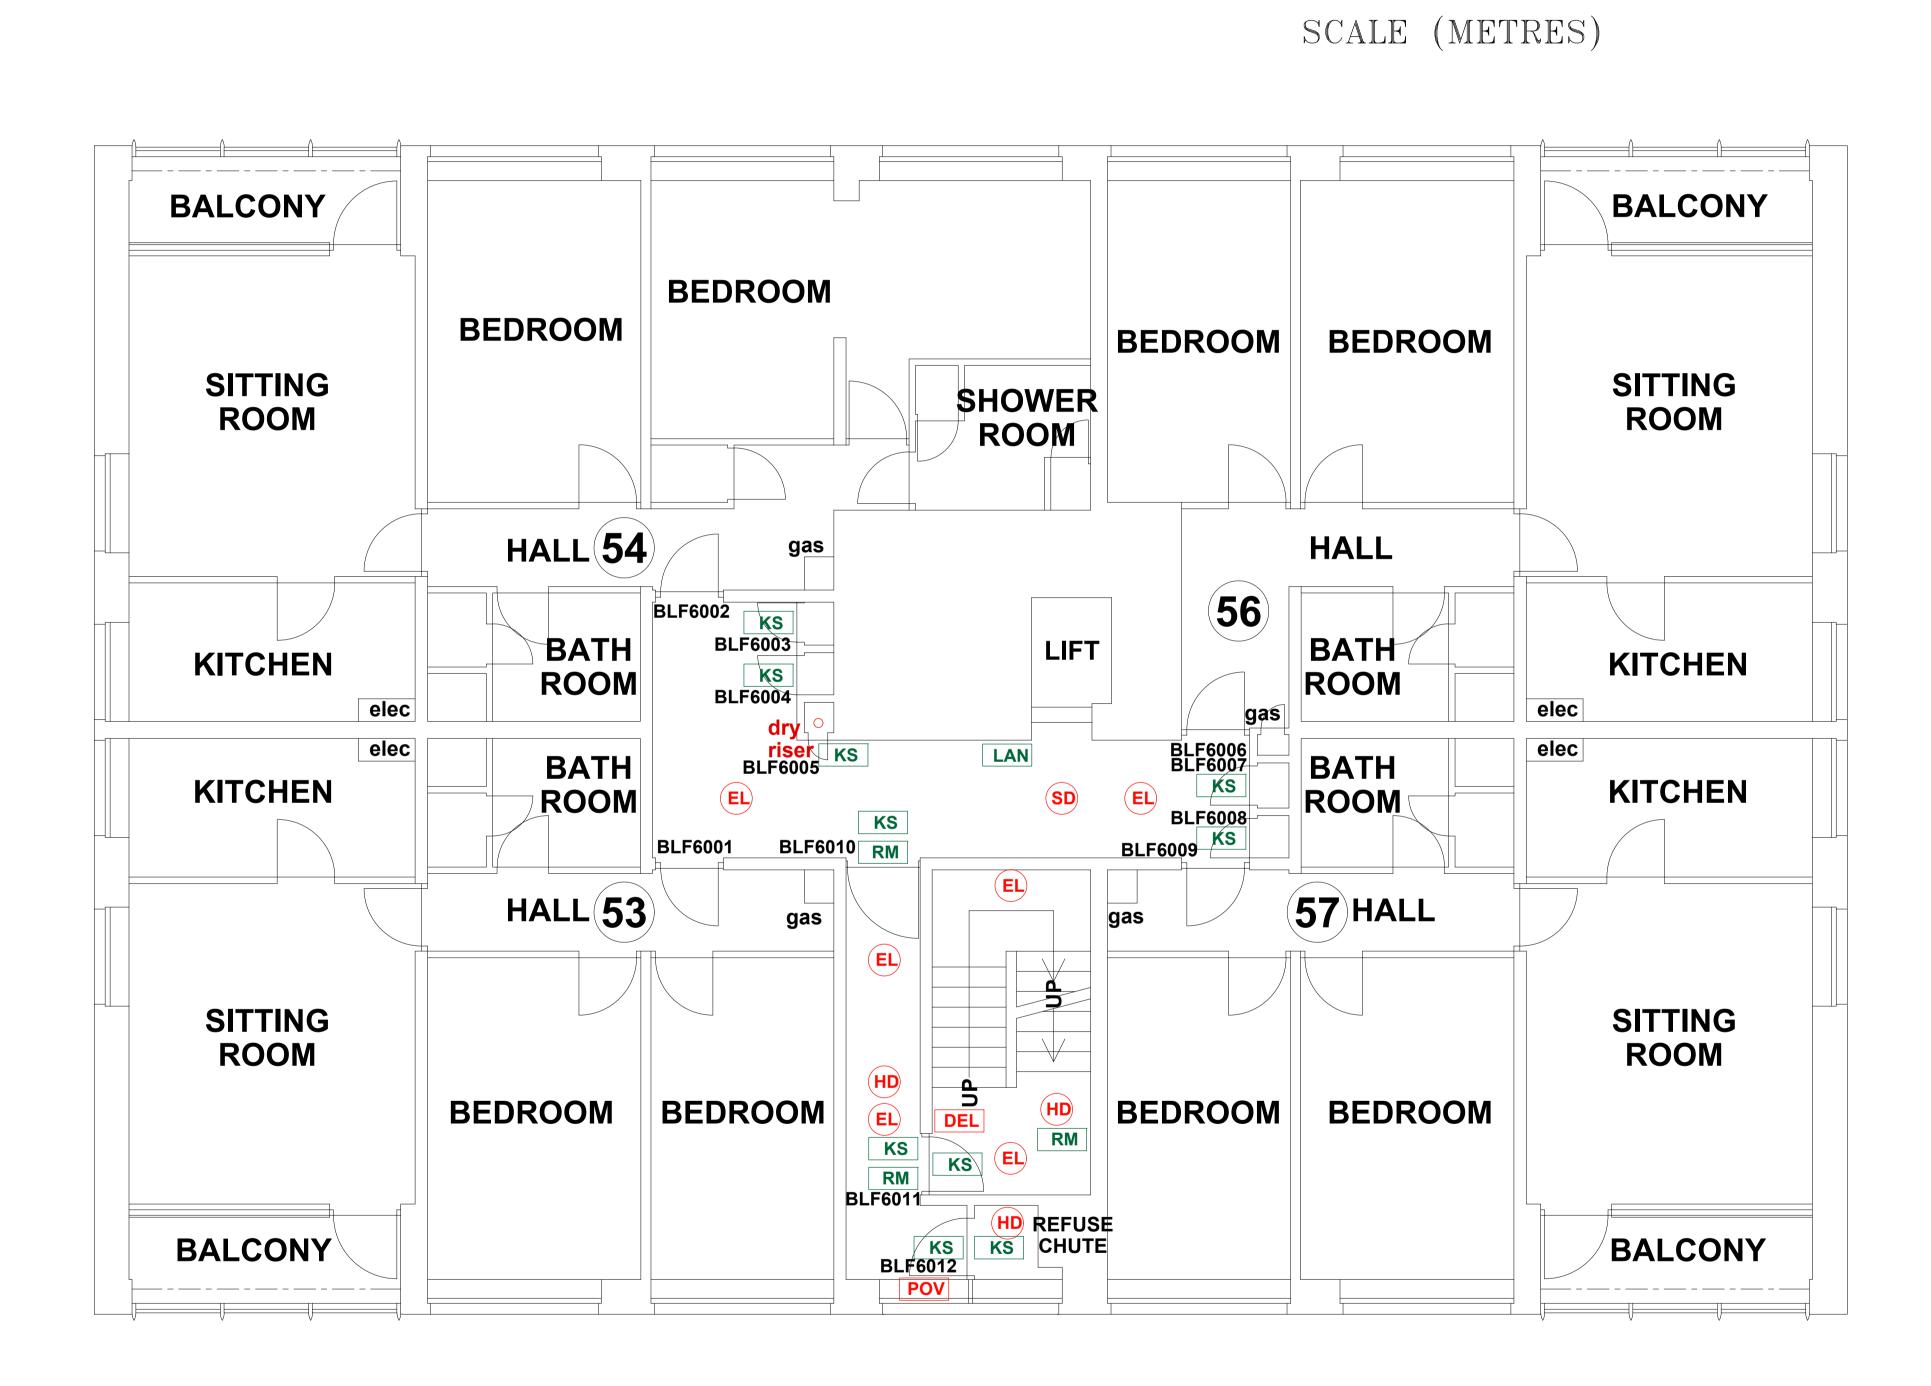

1

5

© COPYRIGHT FIRNTEC LTD 2022

THIS DRAWING IS TO BE READ IN CONJUNCTION WITH ALL RELEVANT SPECIFICATIONS AND DRAWINGS ISSUED. THIS DRAWING IS CORRECT AT TIME OF SURVEY

FIRE PRECAUTIONS LEGEND

ſ)	
L)	

\bigcirc	Break glass type fire alarm call point
HD	Heat sensitive detectors
SD	Smoke sensitive detectors
EL	Emergency light point.
FS	Firemans Switch
DKA	Emergency Drop Key Access
FAP	Fire alarm indicator / repeat panel
GD1	Door/Access fitted with Gerda D1 Key lock
FB1	Door/Access fitted with FB1 Key lock
FB2	Door/Access fitted with FB2 Key lock
FB4	Door/Access fitted with FB4 Key lock
B11P	Door/Access fitted with FB11 Padlock
B14P	Door/Access fitted with FB14 Padlock
DRO	Dry Riser Outlet
DEL	Digital electronic lock door entry/exit system
PIB	Premises Information Box
POV	Permanently Open Vent
AOV	Automatic Opening Vent
OV	Openable Vent
57	Fire alarm sounder ('X' indicates integral flashing - Xenon light)
×	CCTV Security Camera
FB	Fire Brigade Key Access <u>EXTINGUIS</u> H
BLNKT	1.1m x 1.1m fire blanket - base of container to be 1500mm above floor level
AF/6	6 litres AFFF aqueous foam extinguisher to BS:6575
C⁄9	9 litre wet chemical type extinguisher
DP/4.5	4.5 litre dry powder type extinguisher
<u>~</u>	2 kg carbon dioxide type extinguisher
CO /4.5	4.5 kg carbon dioxide type extinguisher
W 9	9 kg water type extinguisher
W ₆	6 litre water type extinguisher
	FIRE EXIT SIGNAGE
E	'E' Signs to be externally illuminated by adjacent emergency light point
FE	'FE' denotes as previous but illuminated as part of sign
RM	'RM' denotes non illuminated sign
	FIRE DOOR SIGNS AND FIRE ACTION NOTICES
FAN	Fire Action Notice
EFP	Emergency Floor Plan
KS	"FIRE DOOR KEEP SHUT" sign
KL	"FIRE DOOR KEEP LOCKED" sign
KC	"AUTOMATIC FIRE DOOR KEEP CLEAR" or "FIRE EXIT KEEP CLEAR" sign
LAN	"CAUTION, IN THE EVENT OF FIRE DO NOT USE THIS LIFT"
DB	DISTRIBUTION BOARD

REV DATE AMENDMENTS



 PROJECT:
 BROWNLEY COURT

 ADDRESS:
 BROWNLEY COURT

 WYTHENSHAWE
 MANCHESTER

 M22 8UD
 MANCHESTER

 DWG NO.:
 BR-C_220020I_007

 DWG TITLE:LEVEL 6
 MOVEMBER 2022

 DWG SIZE:
 SCALE I:50 @ AI

 DRAWN: NR
 CHECKED: BR